

ATED
ND
ND
DING.
PLACE
RS
TS
S OF
S
ATUS
CE TO
IN PLACE

SUMMARY OF NEW BUILDING PROGRAMMED AREAS:

REQUESTED NET AREA FOR EACH FUNCTION TOTALS: 4755 SF.
 ADD 20% FOR WALLS AND CIRCULATION = **PROGRAM of 5706 SF**
NEW BUILDING GROSS AREA AS DESIGNED HERE IS 5771 SF

GENERATOR PAD TO REMAIN WHERE IT IS.

♿	▨	♿				


JAY WHITE, ARCHITECT, PLC
 100 State Street, Suite 230, Montpelier, Vermont 05602
 Email: jaywhitevt@gmail.com Phone: (802) 793-1850

PROJECT:
NORWICH FIRE AND POLICE FACILITIES
 NORWICH, VERMONT
 JOB No. 16-08

TITLE:
FLOOR PLAN
 SCALE: 1/16" = 1' 0" (IF PRINTED 1/16")

ISSUE DATE:
6 22 16
 REVISIONS:

SHEET No.
A101

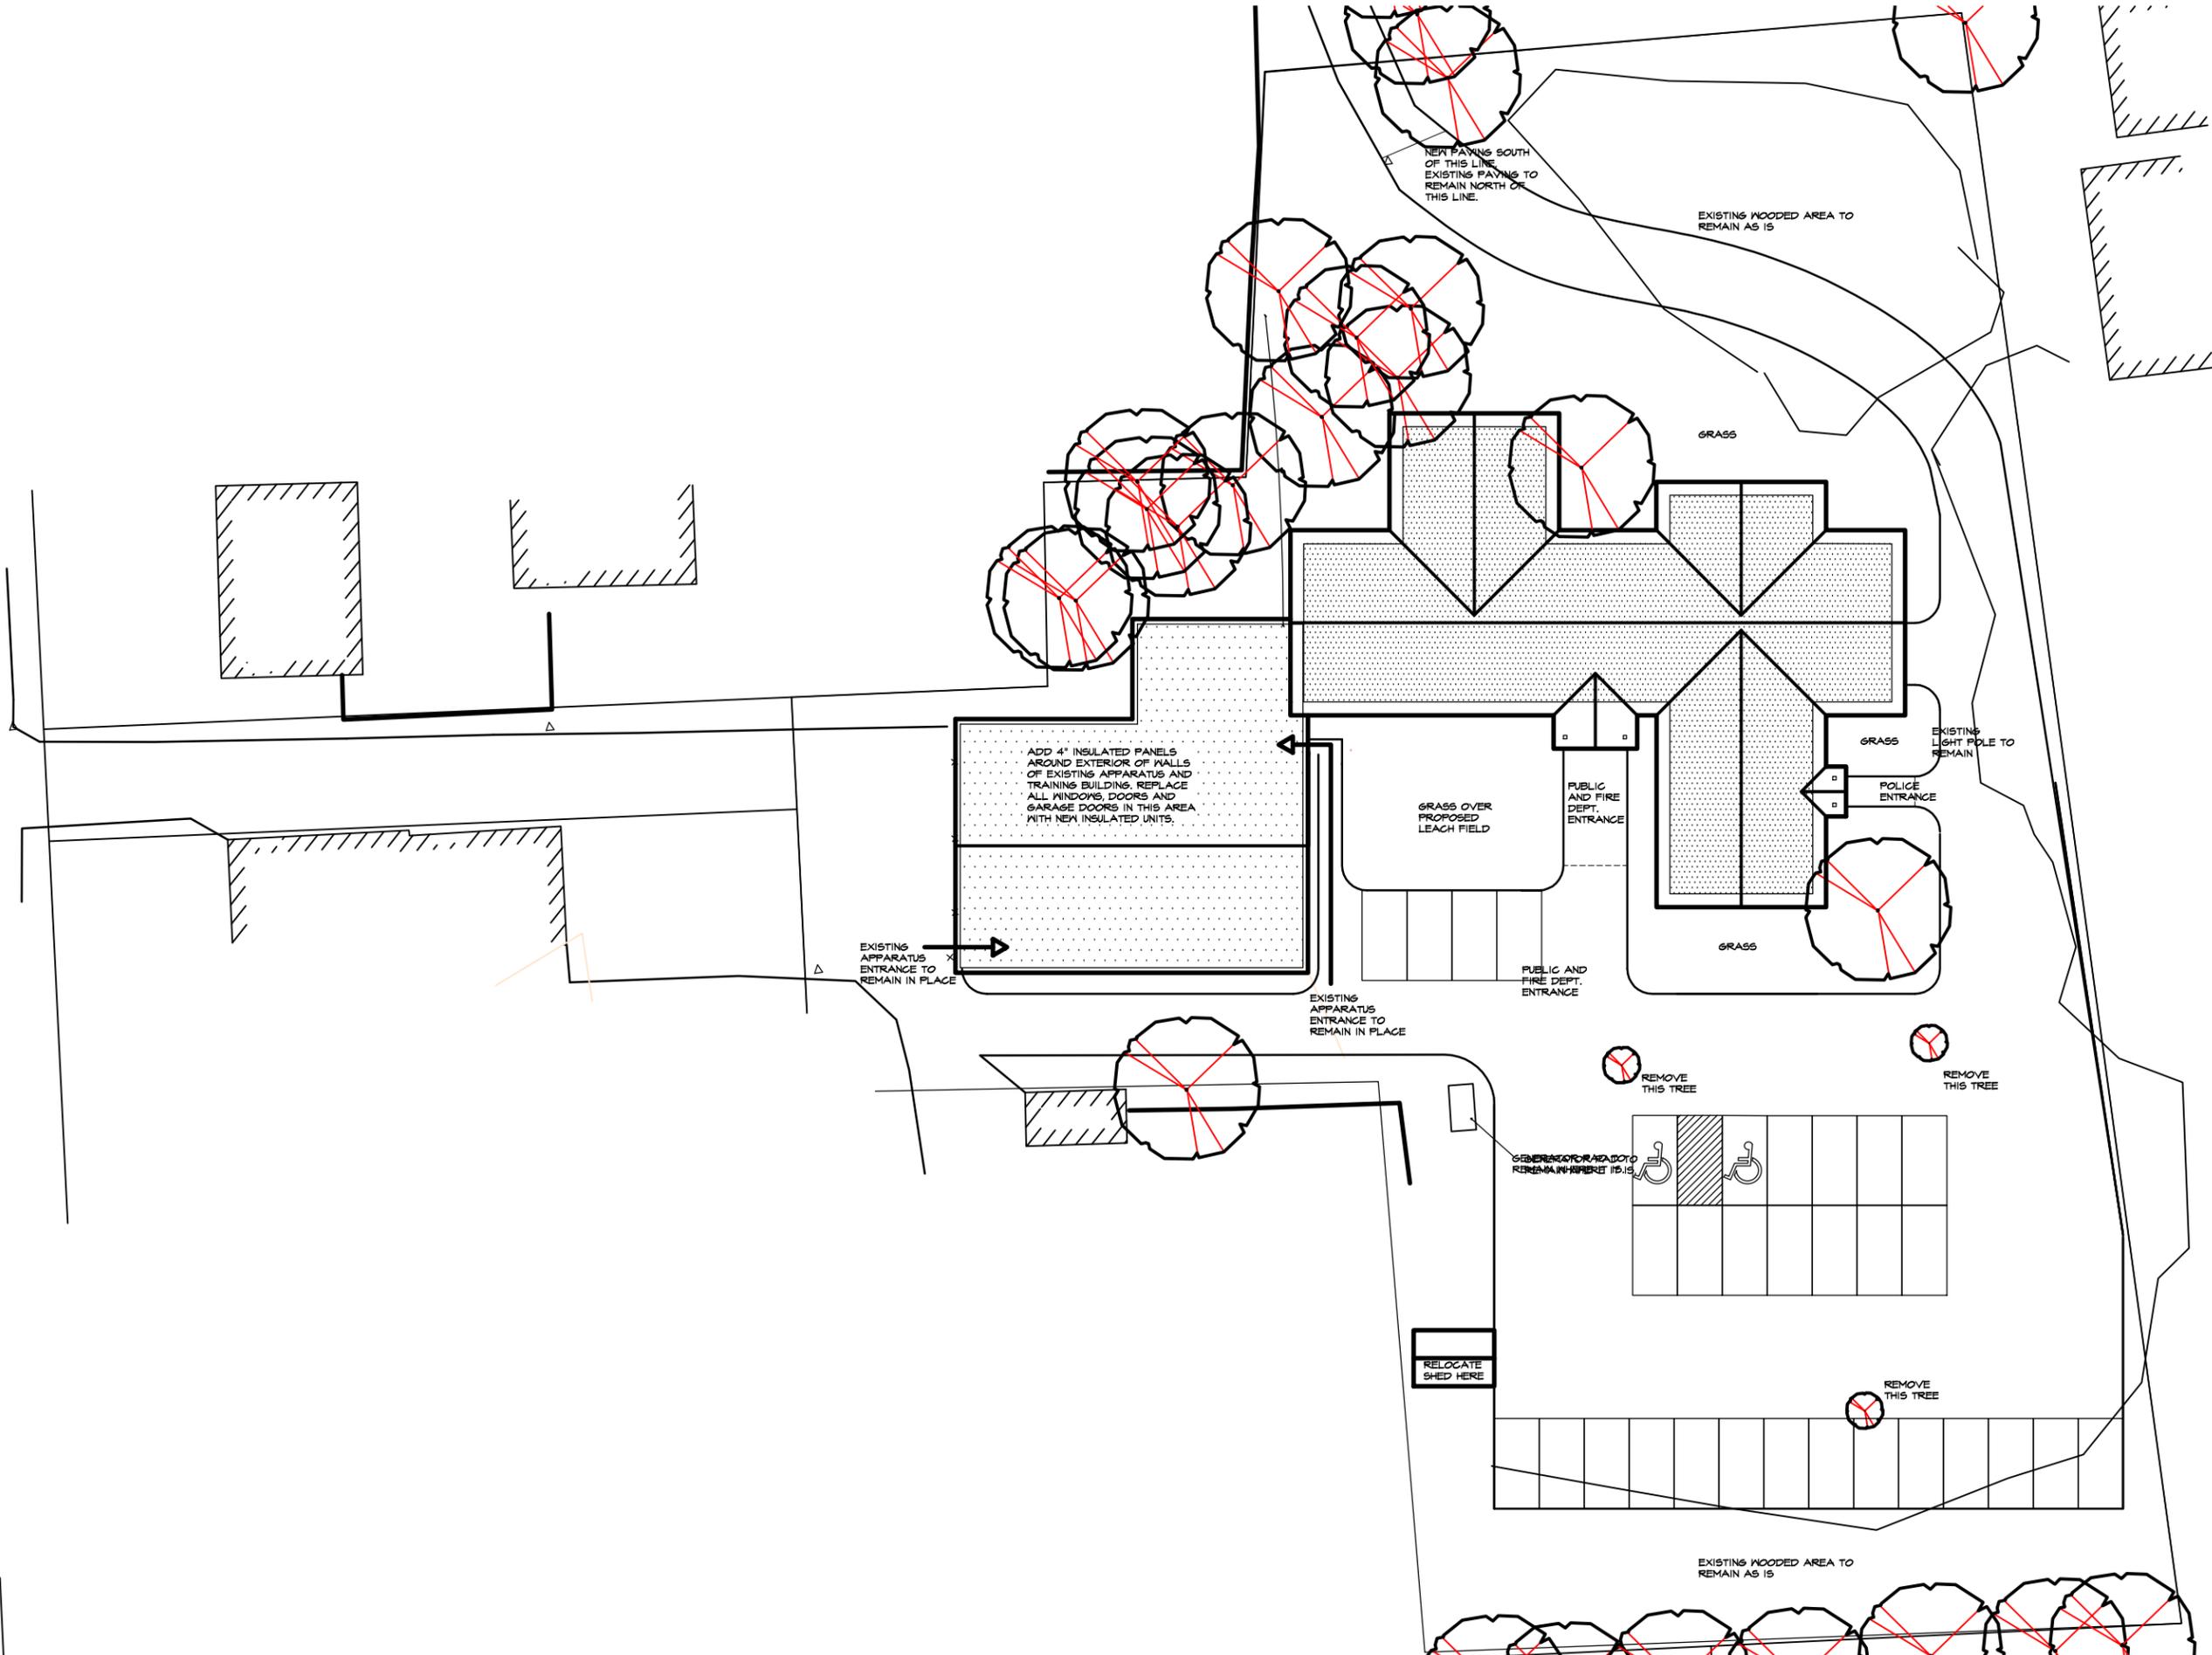

JAY WHITE, ARCHITECT, PLC
 100 State Street, Suite 230, Montpelier, Vermont 05602
 Email: jaywhitevt@gmail.com Phone: (802) 793-1850


PROJECT:
NORWICH FIRE AND POLICE FACILITIES
NORWICH, VERMONT
JOB NO. 16-03

TITLE:
SITE PLAN
SCALE: 1/32" = 1' 0" (IF PRINTED 1/16")

ISSUE DATE:
6 22 16
REVISIONS:

SHEET NO.
00 - 1

© ALL RIGHTS RESERVED, Jay White, Architect, PLC

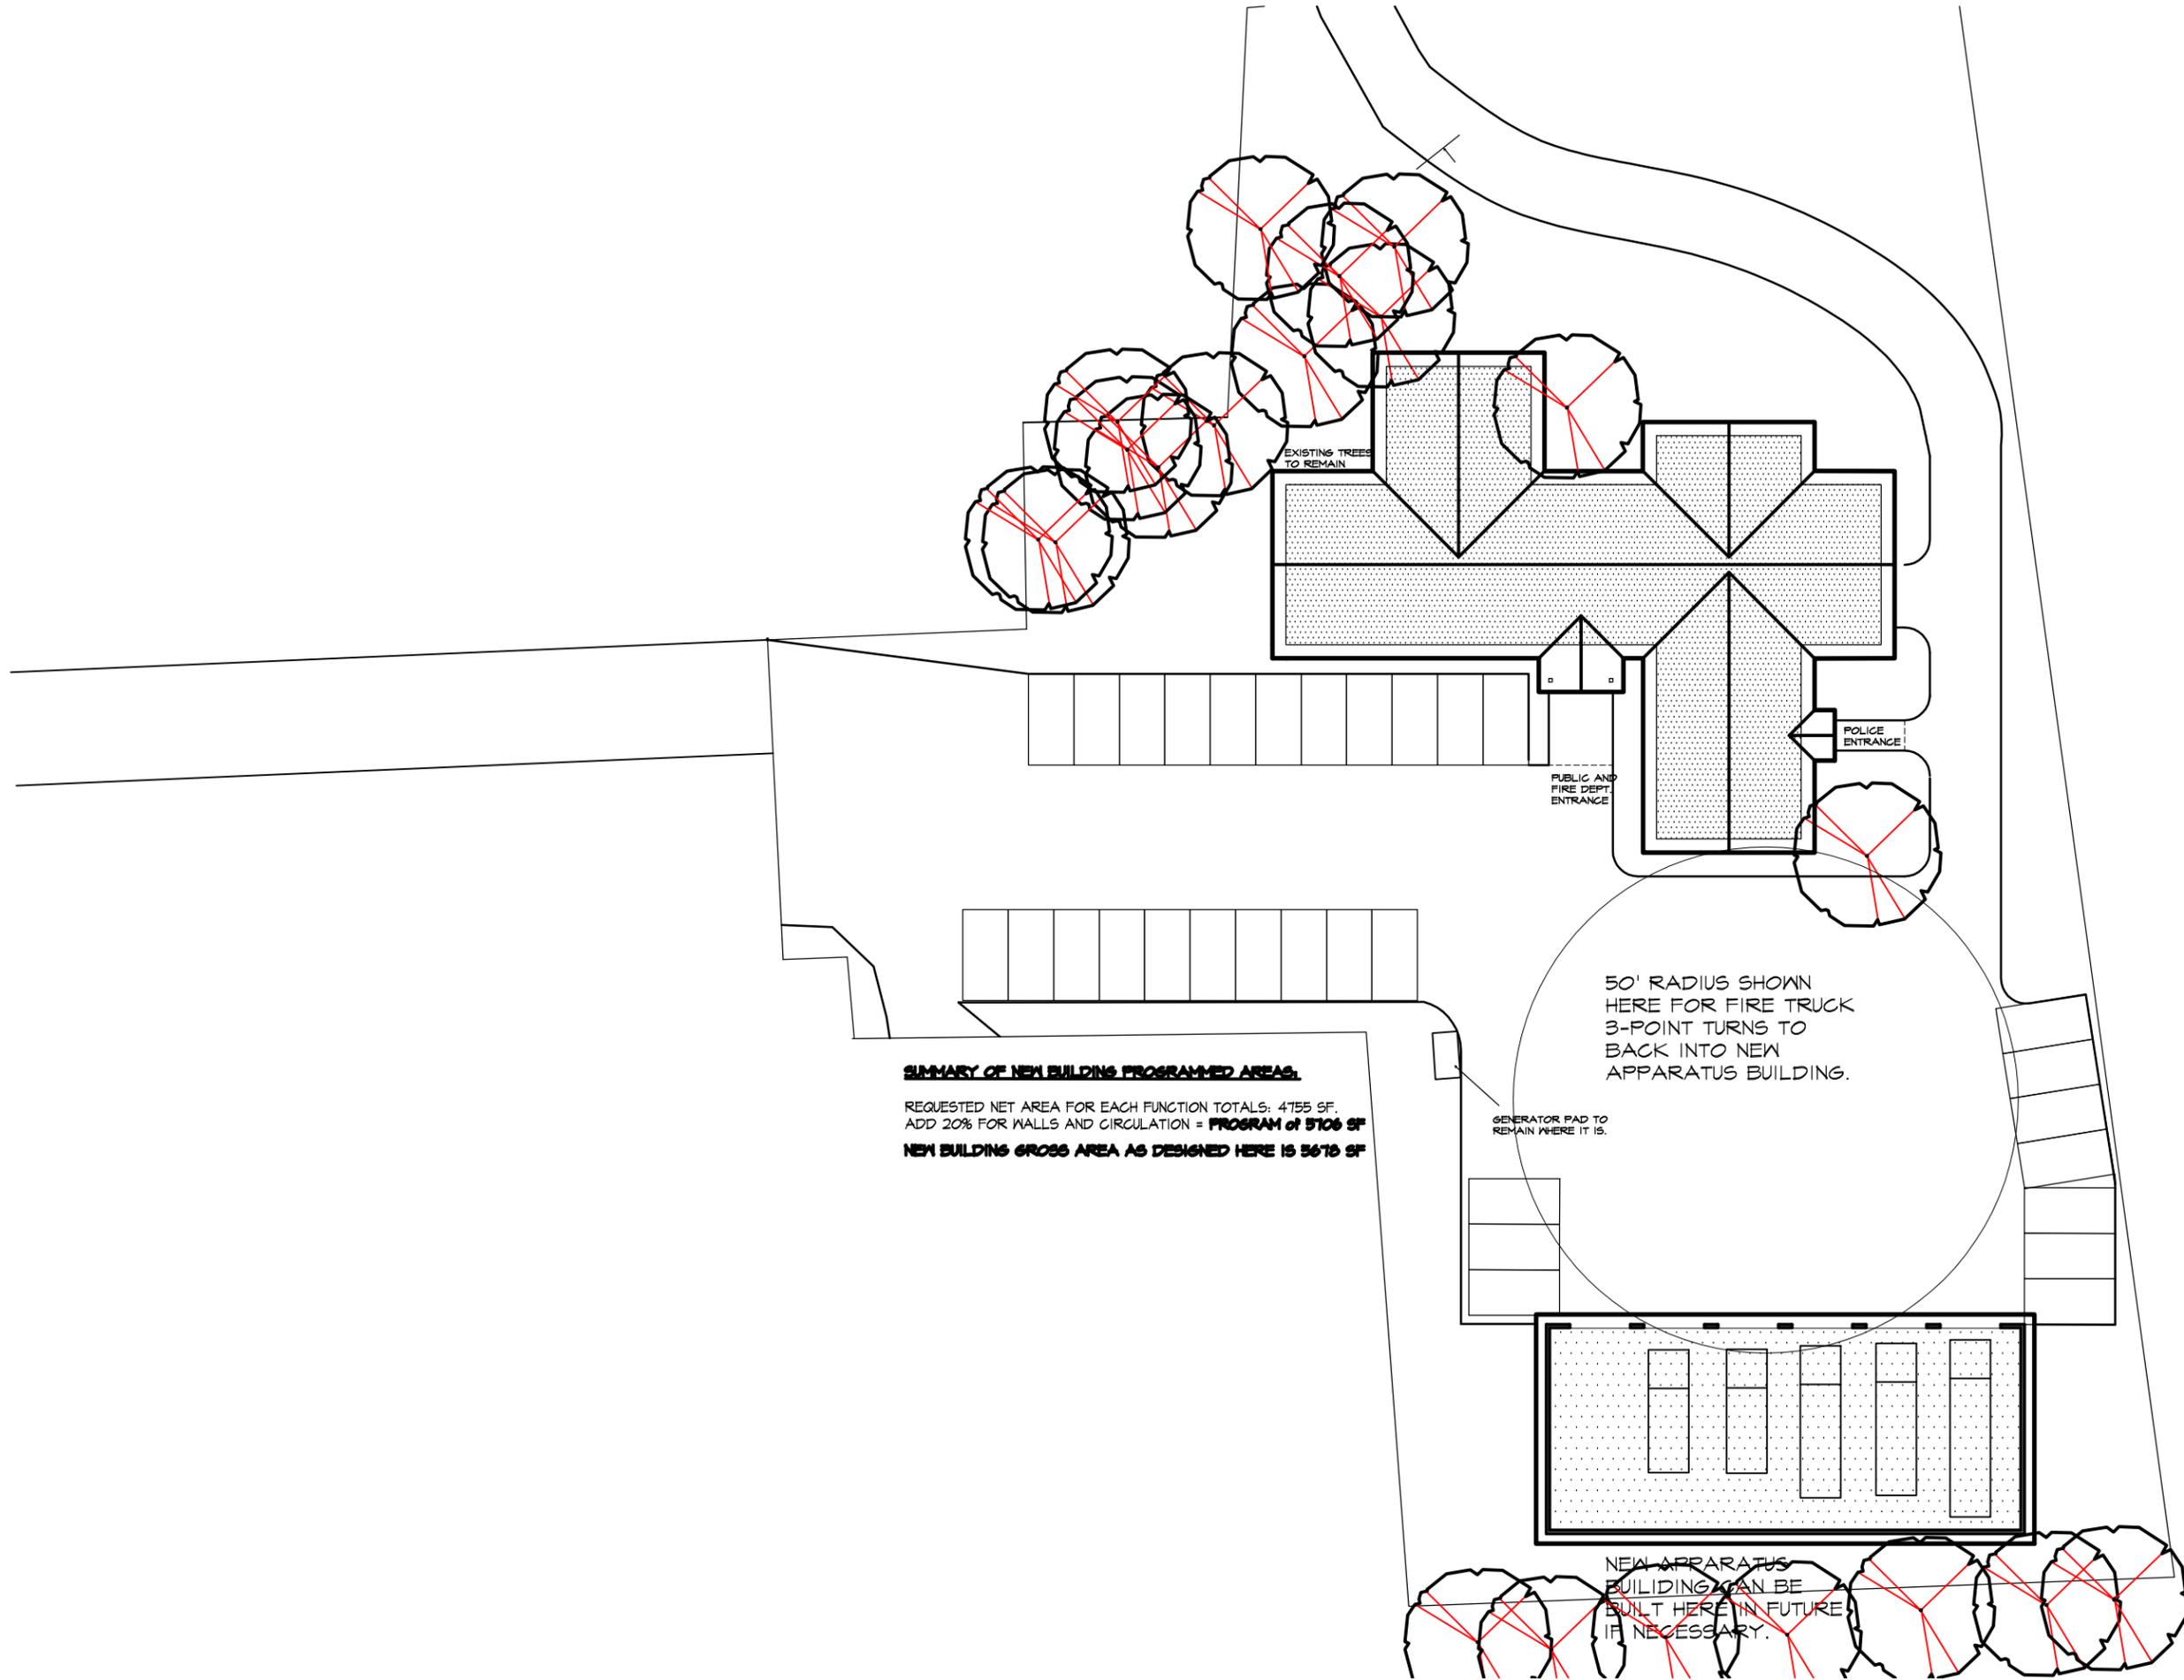

SUMMARY OF NEW BUILDING PROGRAMMED AREAS.

REQUESTED NET AREA FOR EACH FUNCTION TOTALS: 4755 SF.
 ADD 20% FOR WALLS AND CIRCULATION = **PROGRAM of 5706 SF**
NEW BUILDING GROSS AREA AS DESIGNED HERE IS 5676 SF

JAY WHITE, ARCHITECT, PLC
 100 State Street, Suite 230, Montpelier, Vermont 05602
 Email: jaywhitevt@gmail.com Phone: (802) 793-1850

PROJECT:
NORWICH FIRE AND POLICE FACILITIES
NORWICH, VERMONT
JOB No. 16-03

TITLE:
SITE PLAN SHOWING LOCATION OF FUTURE APPARATUS BUILDING
SCALE: 1/32" = 1'-0" (IF PRINTED 11X17)

ISSUE DATE:
6 22 16
REVISIONS:

SHEET No.
50 2